


NOTES:
1. ALL FINAL MATERIALS ARE TO BE CHOSEN BY THE HOME OWNER.
2. FINAL NUMBER OF EXTERIOR STEPS WILL BE DETERMINED ON SITE BY GRADE.
3. CONTRACTOR MUST MEET OR EXCEED ALL APPLICABLE LOCAL, STATE AND FEDERAL REQUIREMENTS.
4. DESIGNER ASSUMES NO RESPONSIBILITY FOR CHANGES TO DRAWINGS BY OTHERS DURING CONSTRUCTION.
5. ALL STRUCTURAL INFO SHOWN ON PLANS ARE FOR INFORMATION ONLY. CONTRACTOR SHALL OBTAIN ALL NECESSARY STRUCTURAL ENGINEERING AND DESIGN FOR ALL STRUCTURAL ELEMENTS.




DATE: 1-9-2025
SUBDIVISION:
BUILDER:

**SOUTHEASTERN CONSTRUCTION
HOMES & DEVELOPMENT**

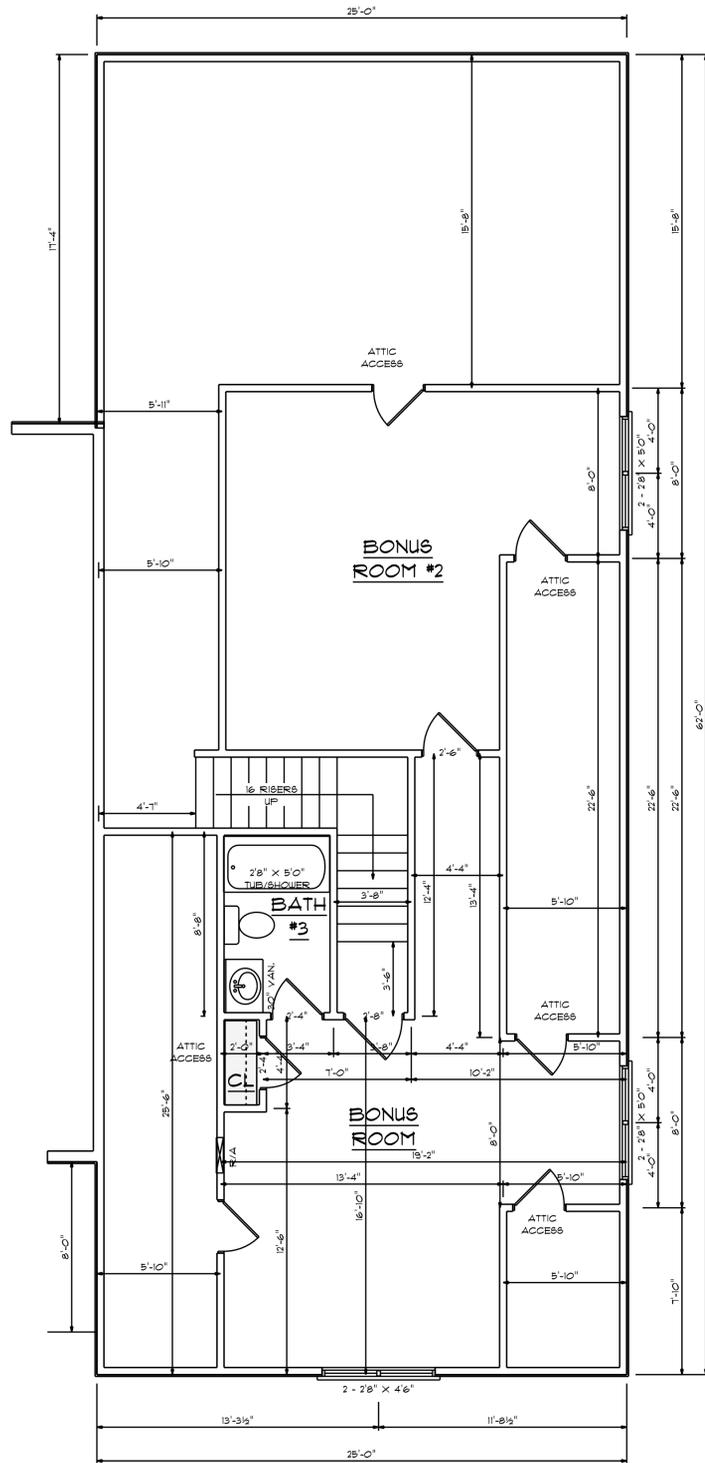

BONUS ROOM
SCALE: 1/4" = 1'0"

682 S/F IN BONUS ROOM
DOESN'T INCLUDE STAIRS

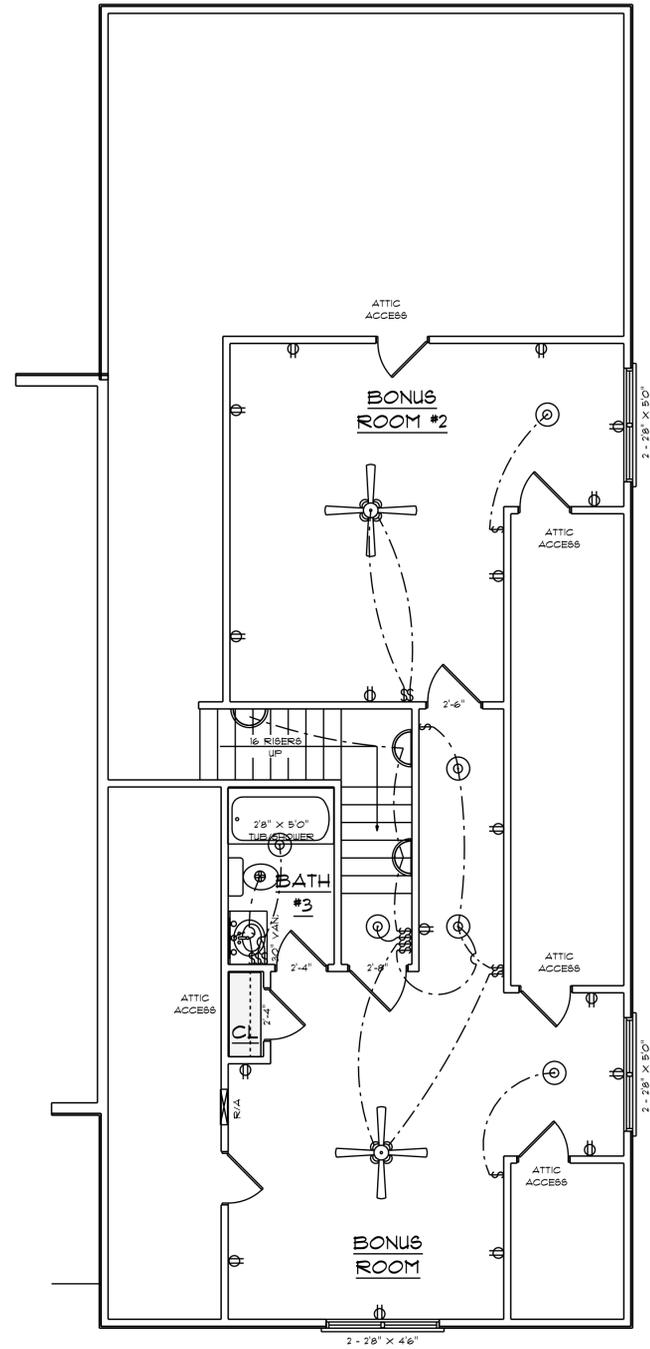


ELECTRICAL CONTRACTOR TO CONFIRM LOCATION OF OUTLET AND FIXTURES, SEE HOME OWNER FOR TYPE AND STYLE OF ELECTRICAL FIXTURES

**ELECTRICAL PLAN
BONUS ROOM**
SCALE: 1/4" = 1'0"

ELECTRICAL LEGEND		
ELECTRICAL	COUNT	SYMBOL
ceiling fan spotlights 01	2	
ceiling dish round	6	
fan	1	
switch	1	
switch - rocker style	2	
switch double	2	
switch quad	1	
switch triple	1	
italian sconce 01	3	
vanity bar light 02	1	
outlet	17	

OPENING SCHEDULE				
PRODUCT CODE	SIZE	HINGE	REVERSED	COUNT
18X80 COLONIAL A 1-MODIFIED	2'-4"	L	NO	1
18X80 COLONIAL A 1-MODIFIED	2'-4"	L	YES	1
18X80 COLONIAL A 1-MODIFIED	2'-4"	R	NO	1
18X80 COLONIAL A 1-MODIFIED	2'-4"	R	YES	2
28X80 COLONIAL A 1	2'-4"	R	NO	1
28X80 COLONIAL A 1	2'-4"	R	YES	1
30X80 COLONIAL A 1	2'-6"	L	YES	1
32X80 COLONIAL A 1	2'-8"	L	YES	1
18X24 DOUBLE HUNG 1-MODIFIED	2'-2'8" X 4'6"	NN	NA	1
18X24 DOUBLE HUNG 1-MODIFIED	5'-4" X 5'-0"	NN	NA	2

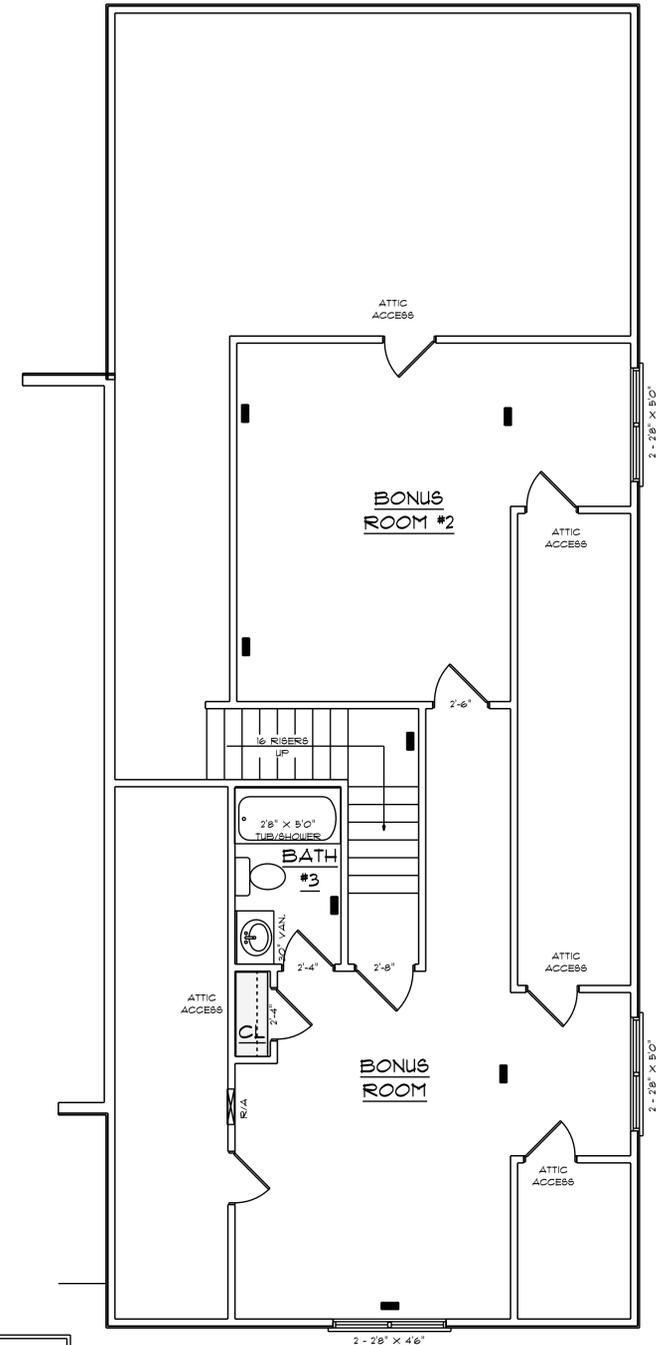

HVAC CONTRACTOR TO CONFIRM VENT LOCATION AND SIZE OF UNIT

**HVAC PLAN
BONUS ROOM**
SCALE: 1/4" = 1'0"

682 S/F IN BONUS ROOM
DOESN'T INCLUDE STAIRS

NOTE:
BUILDING CONTRACTOR TO MEET LOCAL WIND LOADS PER LOCAL CODE AS IT PERTAINS TO LOCATION OF HOUSE (CC, 160, 180, 140, 160, 174)